

ALL CABINETS, FIXTURES & EQPT & HARDWARE REMOVALS TO BE RETURNED TO OWNER U.O.N. (TYP.)
 REMOVE ALL C.T. & VINYL BASE FROM ALL ROOMS TO RECEIVE NEW FLOORING

LEGEND

SYMBOL	DESCRIPTION
(---)	ITEMS TO BE REMOVED
(—)	ITEMS TO BE RETAINED
(---)	NEW PARTITION WALL NEW 92 METAL STUDS @ 400 c/c w/MINERAL WOOL SOUND INSULATION & 12.7 D'WALL BOTH SIDES

ALL NEW MOVABLE FURNITURE BY OTHERS U.O.N. (TYP.)

SNYDER CONSTRUCTION
 AS BUILT DRAWING
 2019-01-22

FOR TENDER & PERMIT APRIL 27/2018

ISSUED: DATE:

THIS DRAWING IS COMPLEMENTARY & MUST BE READ IN CONJUNCTION WITH ALL THE OTHER DRAWINGS AND/OR SPECIFICATIONS. REPORT ANY INCONSISTENCIES TO THE ARCHITECT.

PROJECT:
RENOVATIONS TO ST. PAUL'S CATHOLIC ELEMENTARY SCHOOL


2 GRANT AVENUE, LAKEFIELD, ON

DRAWING TITLE:
**KEY PLAN
 EXIST. PLAN - DEMOLITION & NEW WORK**

SCALE: AS NOTED DRAWING NUMBER:


DRAWN BY: SV
 CHECKED BY: GW

A1 OF 4
 17057

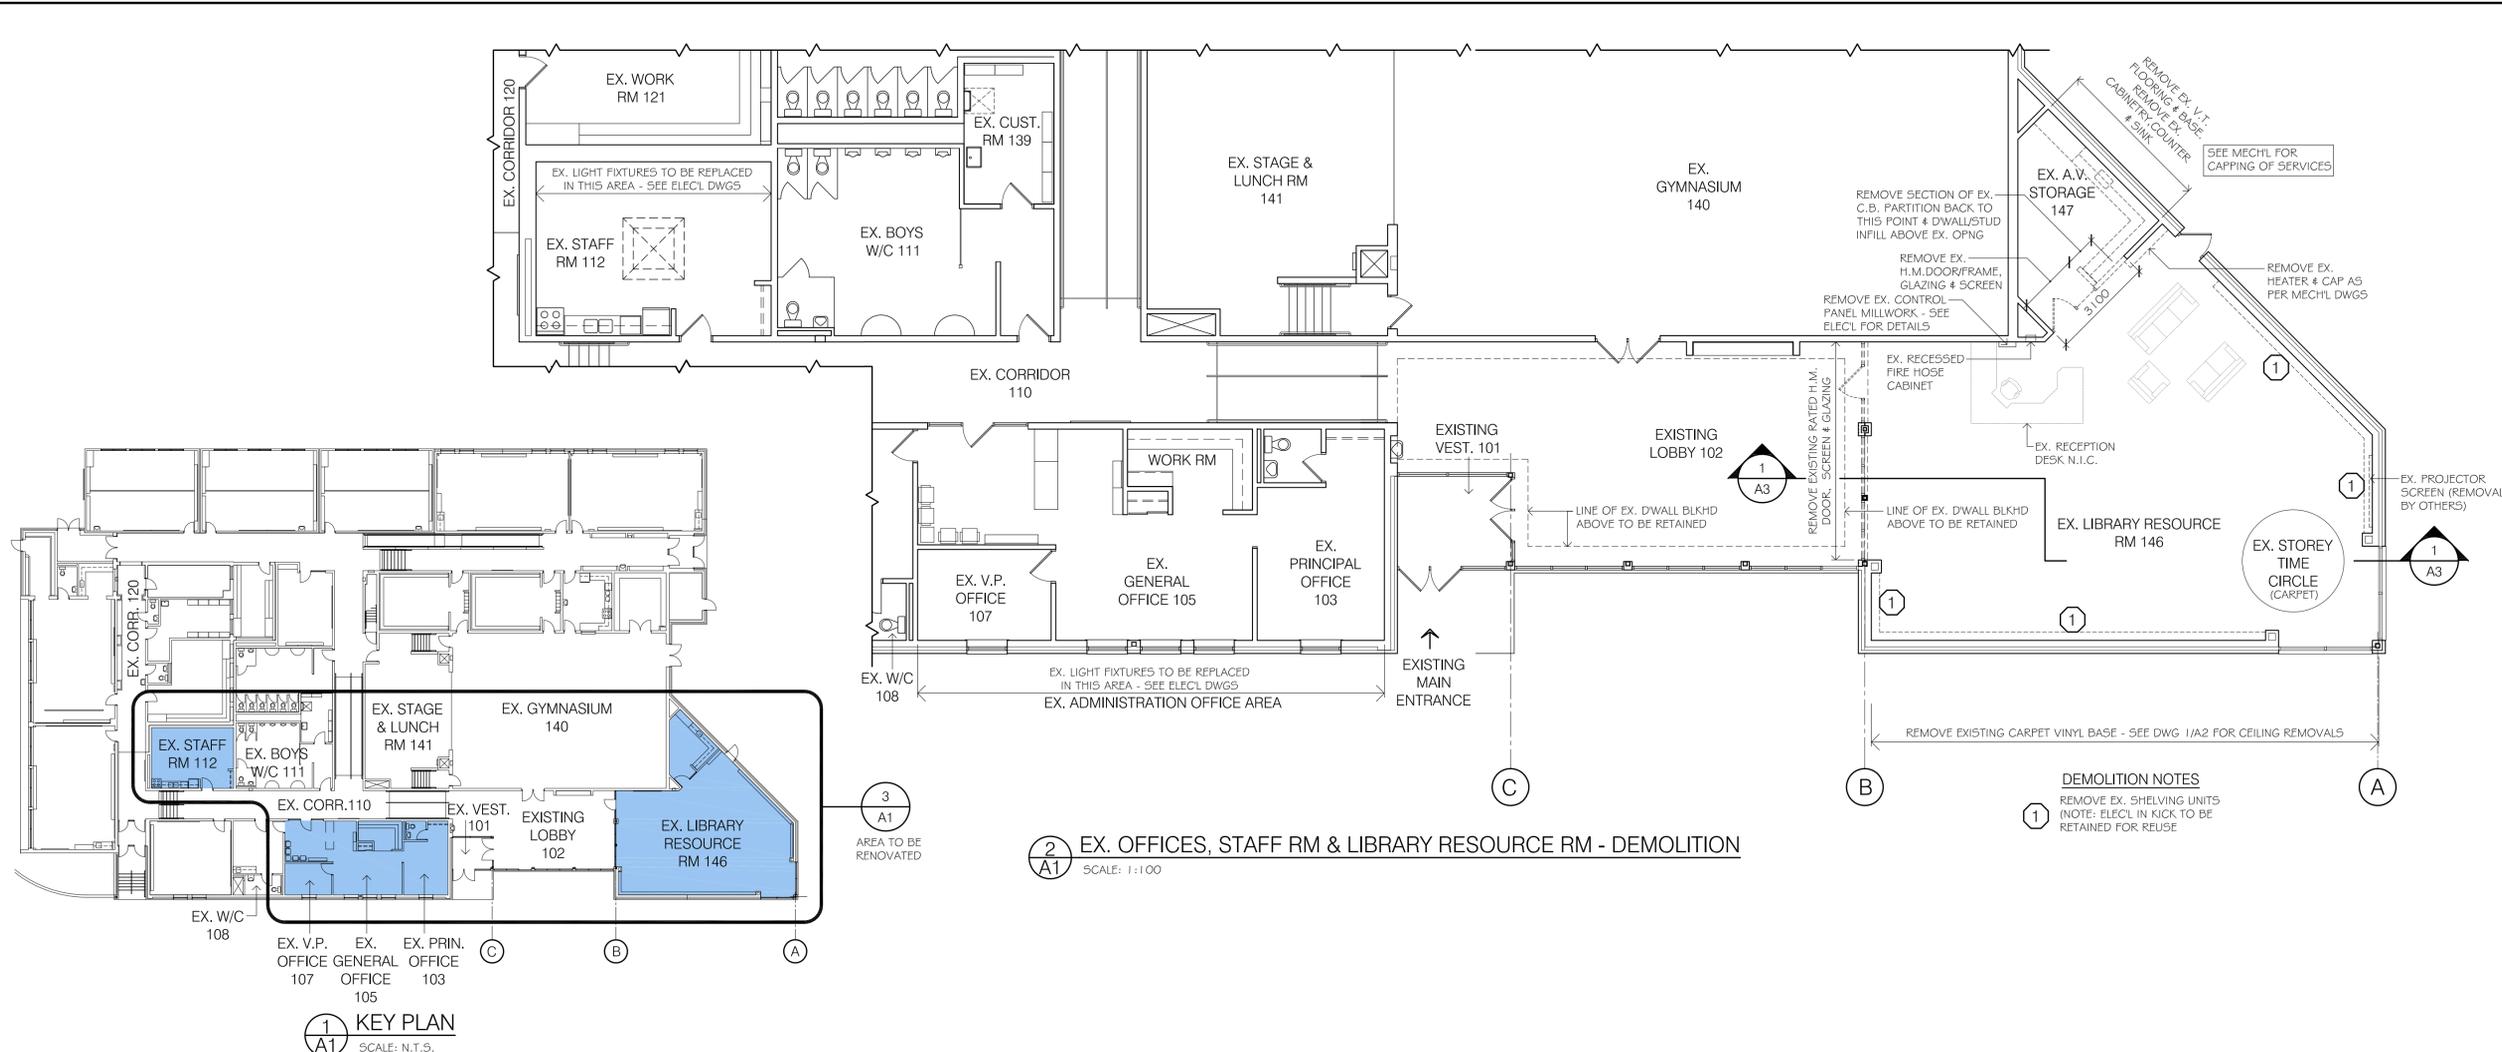


2 EX. OFFICES, STAFF RM & LIBRARY RESOURCE RM - DEMOLITION
 SCALE: 1:100

1 KEY PLAN
 SCALE: N.T.S.

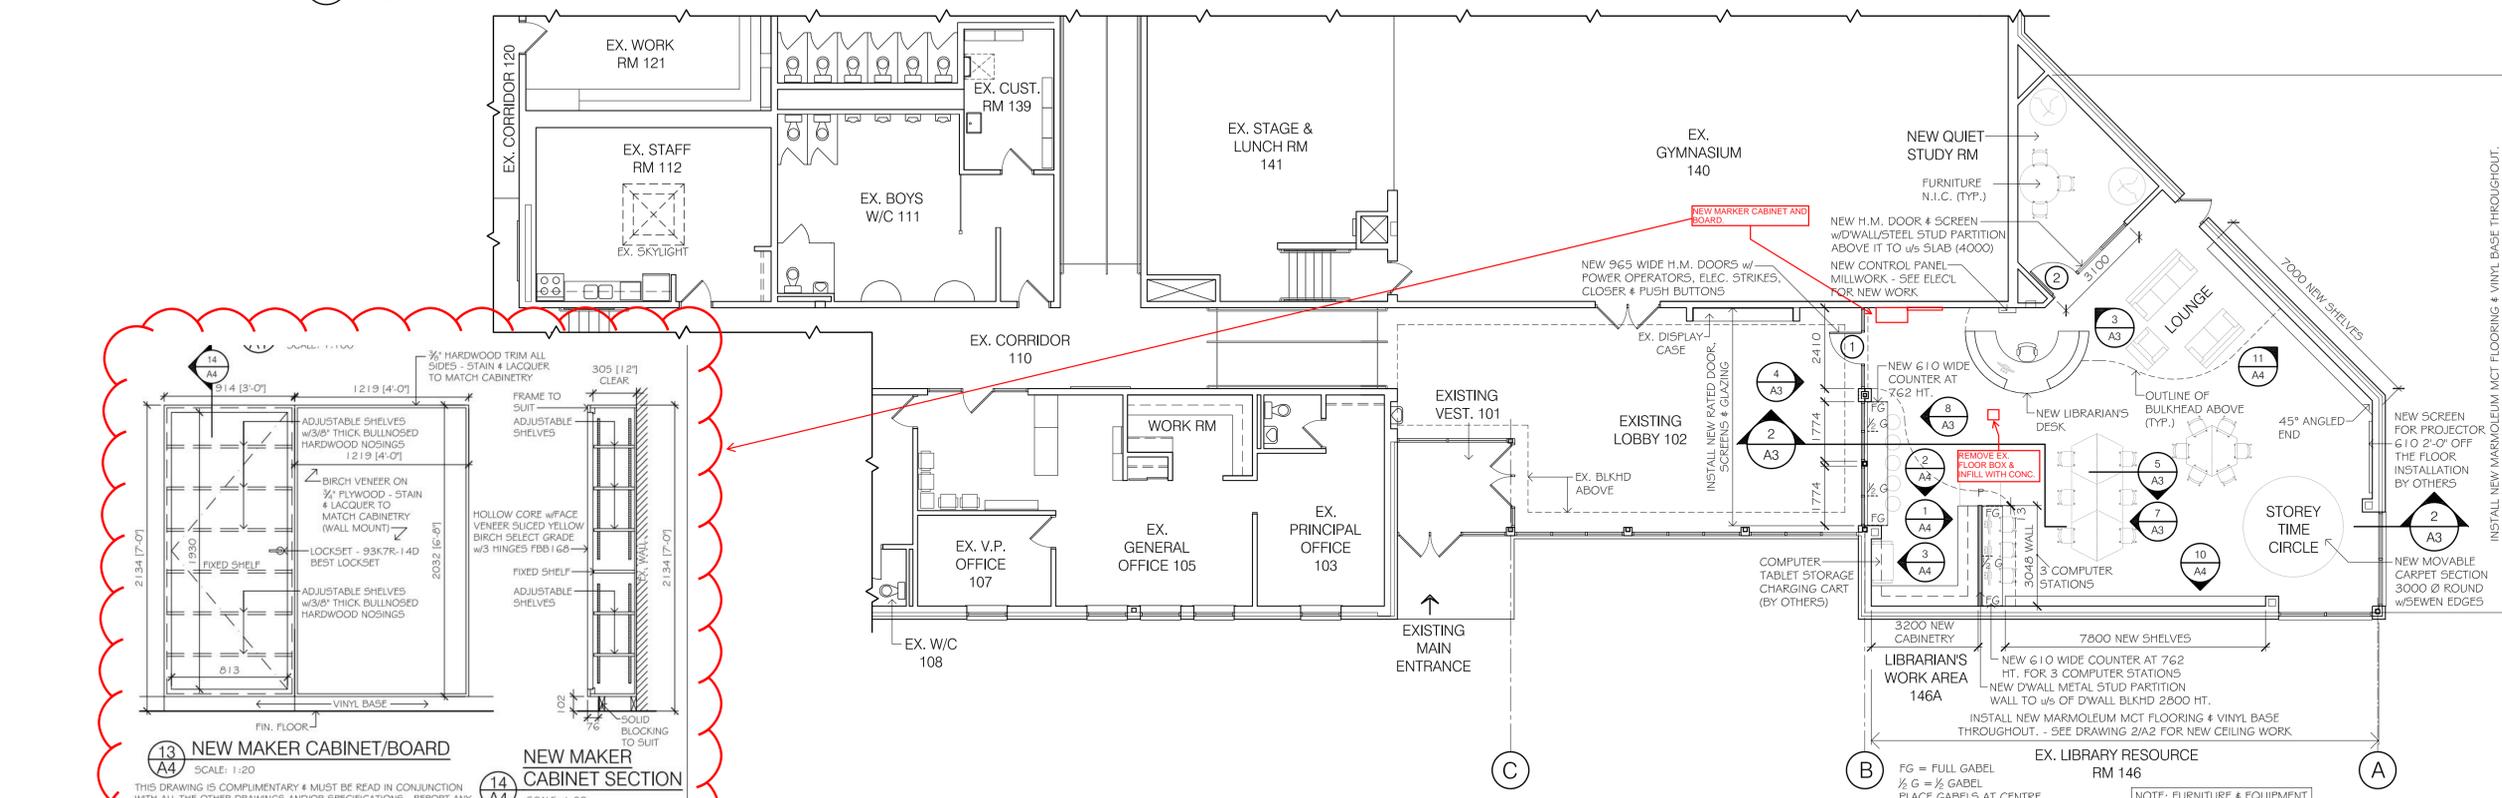

3 EX. OFFICES, STAFF RM & LIBRARY RESOURCE RM - NEW WORK
 SCALE: 1:100

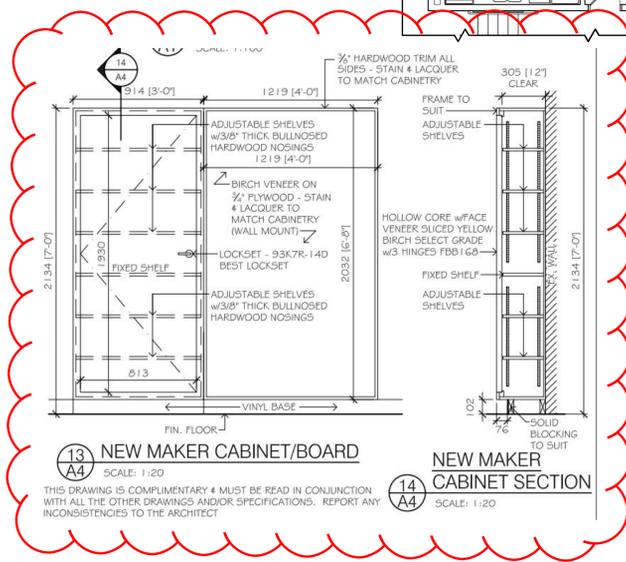

13 NEW MAKER CABINET/BOARD SCALE: 1:20
14 NEW MAKER CABINET SECTION SCALE: 1:20

THIS DRAWING IS COMPLEMENTARY & MUST BE READ IN CONJUNCTION WITH ALL THE OTHER DRAWINGS AND/OR SPECIFICATIONS. REPORT ANY INCONSISTENCIES TO THE ARCHITECT

ELECTRICAL LEGEND REMOVALS

SYMBOL	DESCRIPTION
	1x4 RECESSED FLOURESCENT LIGHT FIXTURE
	POT LIGHT
	SINGLE EMERGENCY LIGHT w/PROTECTIVE COVER
	EXIT LIGHT
	SUPPLY AIR GRILLE
	RETURN AIR GRILLES
	SMOKE DETECTOR
	SPEAKER
	CLG ELEC EQUIPMENT
	JIFFY POLE
	PROJECTOR

TYP. NOTES
 1 REMOVE EX. PROJECTOR & RETAIN FOR REINSTALLATION

ELECTRICAL LEGEND ALL NEW U.O.N.

SYMBOL	DESCRIPTION
	NEW DECO. PENDANT LIGHT
	NEW 600x600 CLG LIGHT
	POT LIGHT
	SUPPLY AIR GRILLE
	SMOKE DETECTOR
	EXIT LIGHT

SEE ELEC'L & MECH'L DWGS FOR ADDITIONAL CLG EQPT & DETAIL

SNYDER CONSTRUCTION
 AS BUILT DRAWING
 2019-01-22

FOR TENDER & PERMIT APRIL 27/2018

ISSUED: DATE:

PROJECT:
RENOVATIONS TO ST. PAUL'S ELEMENTARY SCHOOL


2 GRANT AVENUE, LAKEFIELD, ON

DRAWING TITLE:
REFLECTED CEILING PLANS


SCALE: AS NOTED DRAWING NUMBER:

DRAWN BY: SV
 CHECKED BY: GW


A2 OF 4
 17057

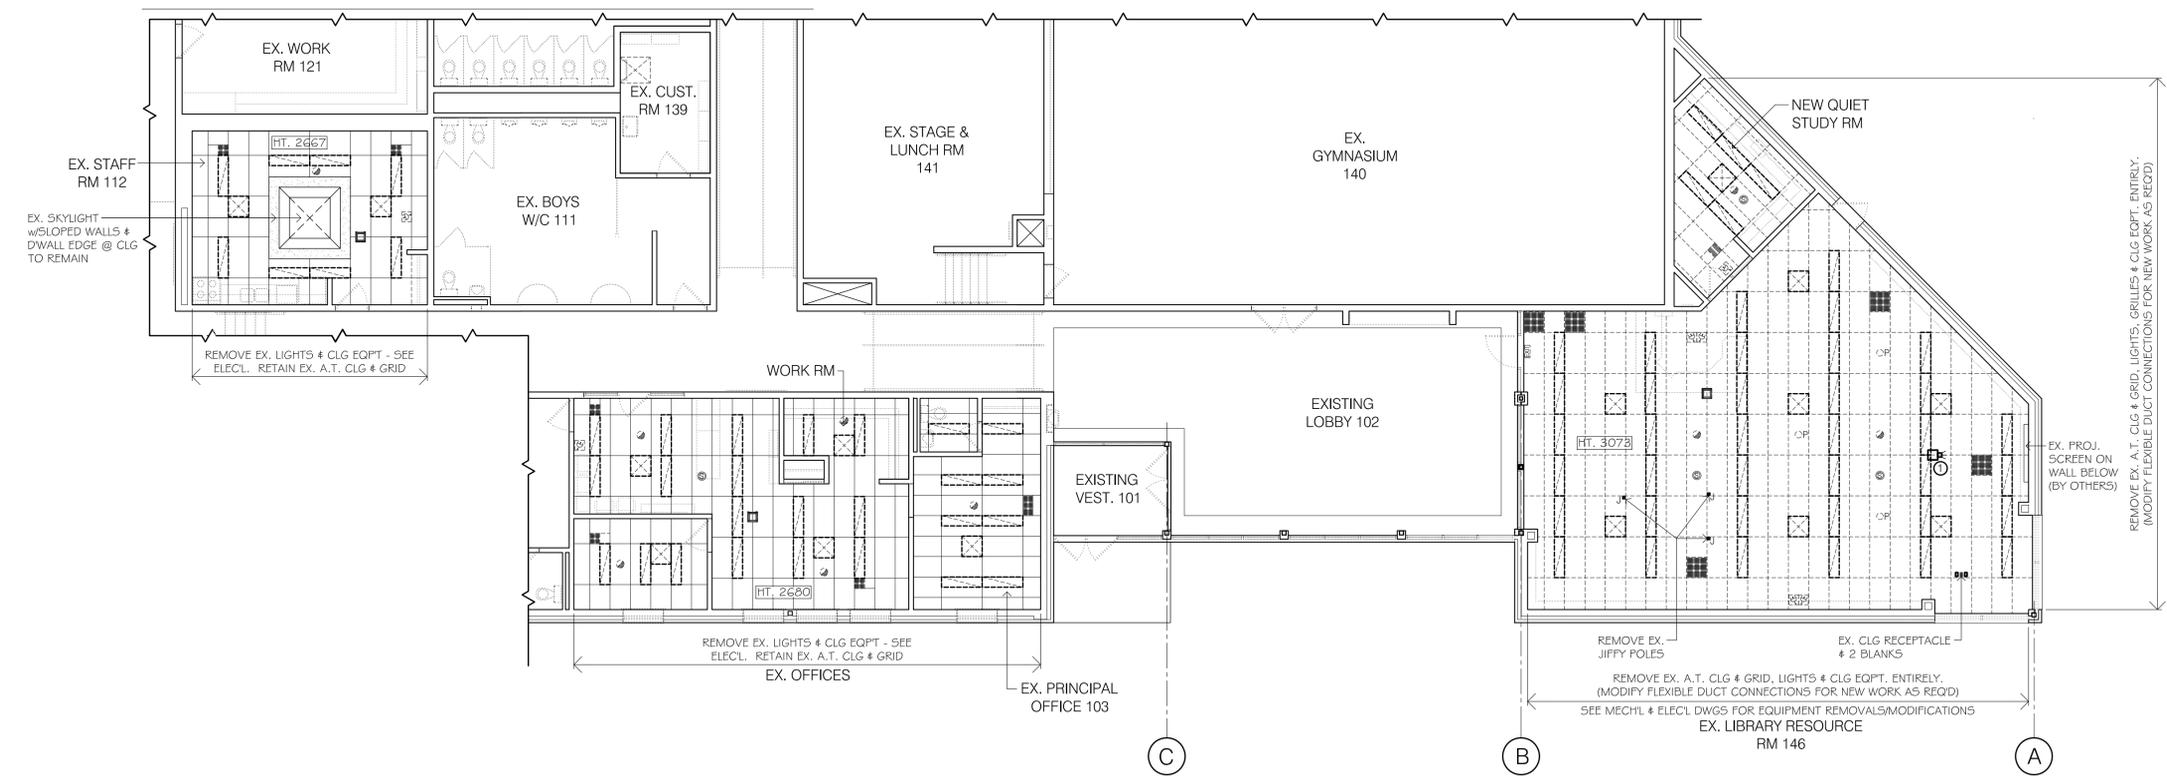


EX. OFFICES, STAFF RM & LIBRARY RESOURCE RM
EX. REFLECTED CEILING PLAN - DEMOLITION
 SCALE: 1:100

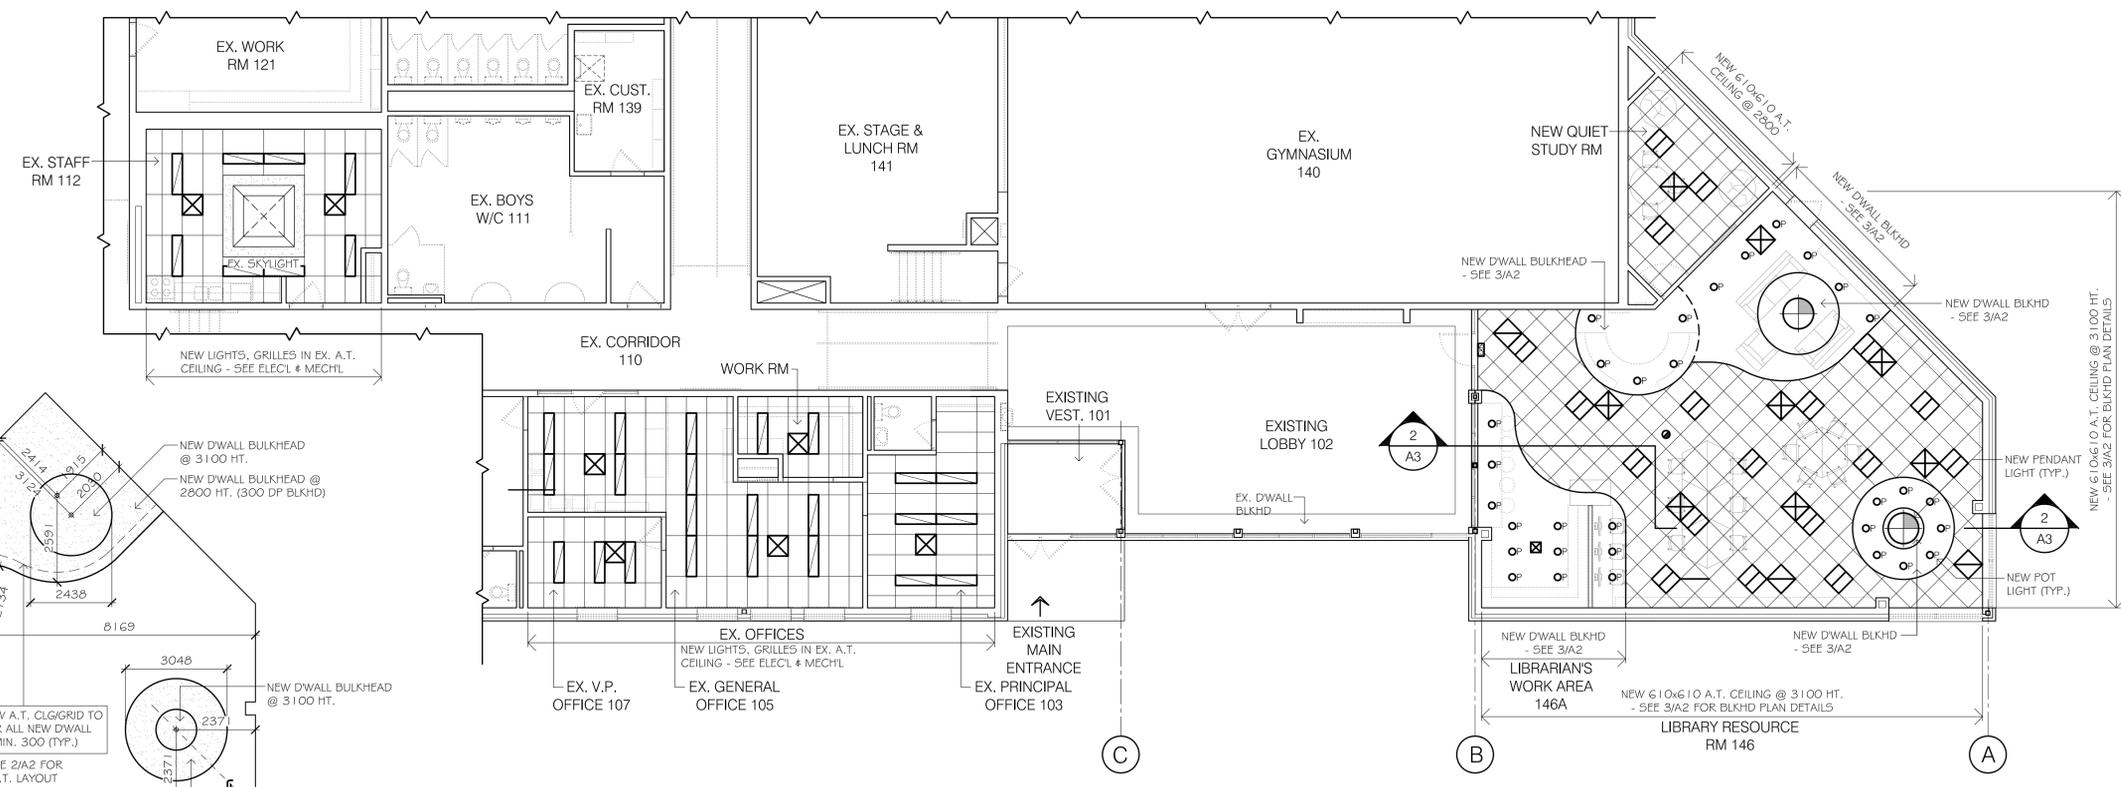


EX. OFFICES, STAFF RM & LIBRARY RESOURCE RM
NEW REFLECTED CEILING PLAN
 SCALE: 1:100
 SEE MECH'L & ELEC'L FOR EQUIPMENT LOCATIONS i.e. LIGHTING & GRILLES

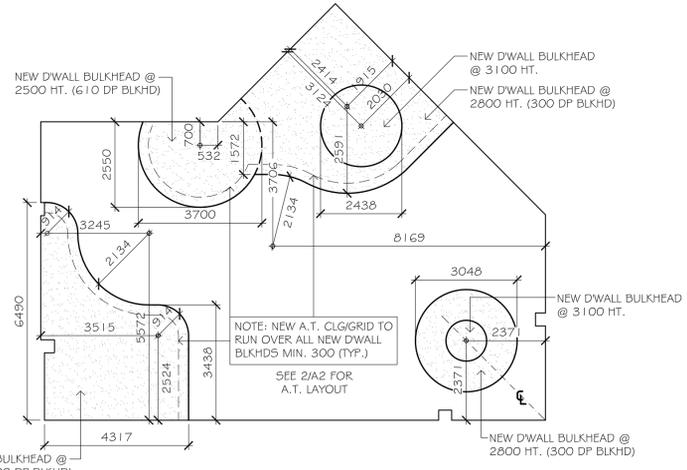


D'WALL BULKHEAD LAYOUT
 SCALE: 1:100

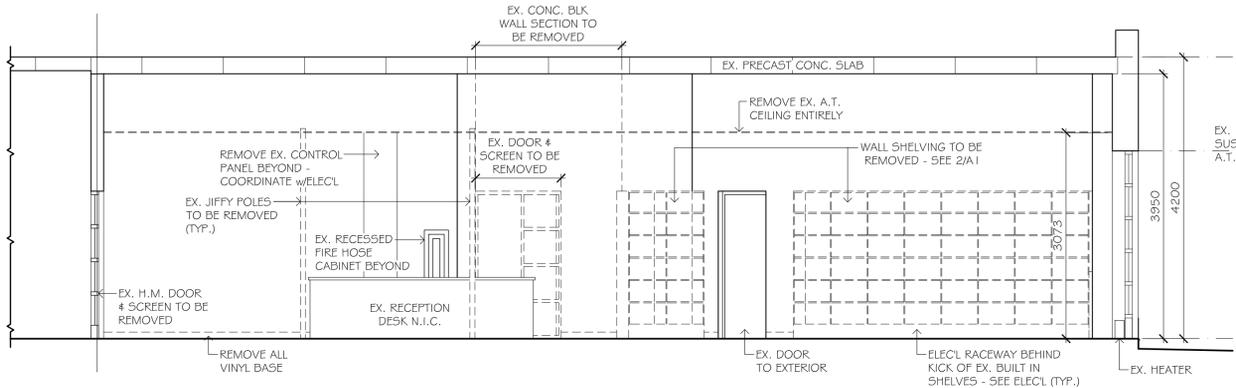


1 SECTION - EX. LIBRARY RESOURCE RM 146 - DEMOLITION (TYP. REMOVALS)
 SCALE: 1:50

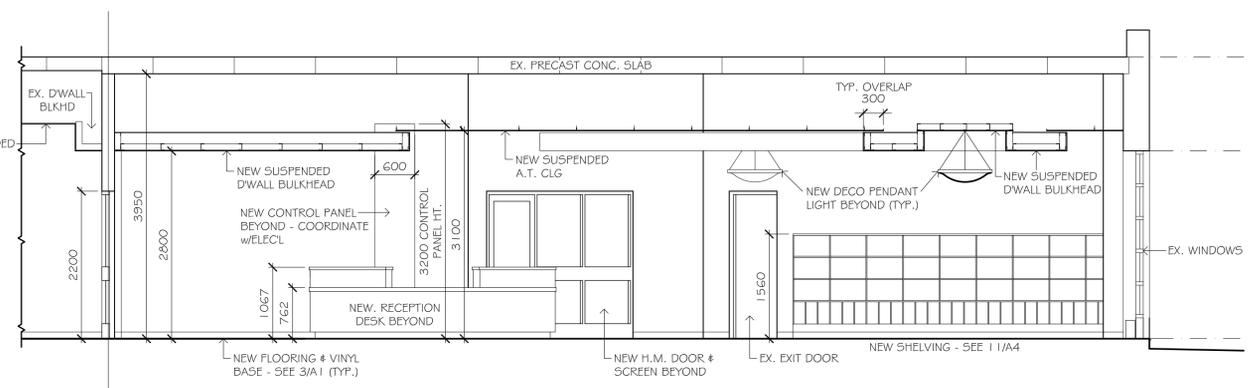


2 SECTION - LIBRARY RESOURCE RM 146 - NEW WORK
 SCALE: 1:50

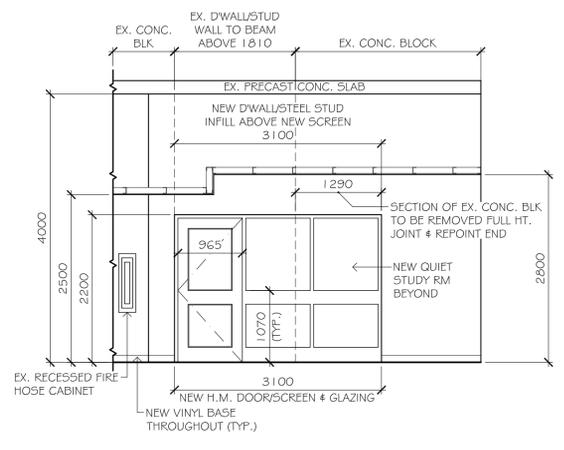


3 NEW QUIET STUDY ROOM SCREEN
 SCALE: 1:50 VIEW FROM LIBRARY RESOURCE RM 146

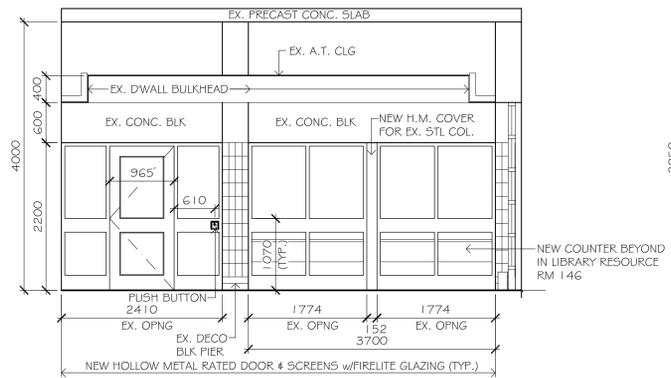


4 NEW LIBRARY ENTRANCE SCREEN
 SCALE: 1:50 VIEW FROM LOBBY 102

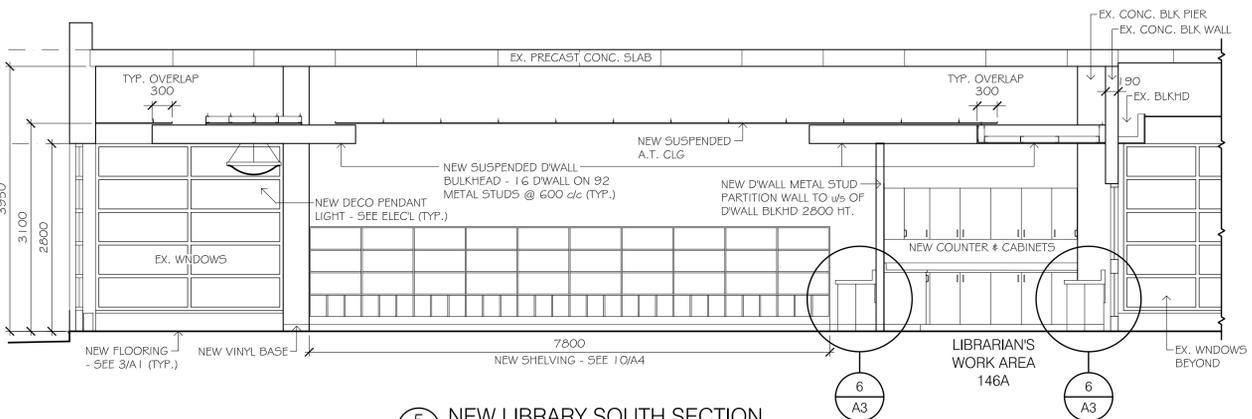


5 NEW LIBRARY SOUTH SECTION
 SCALE: 1:50

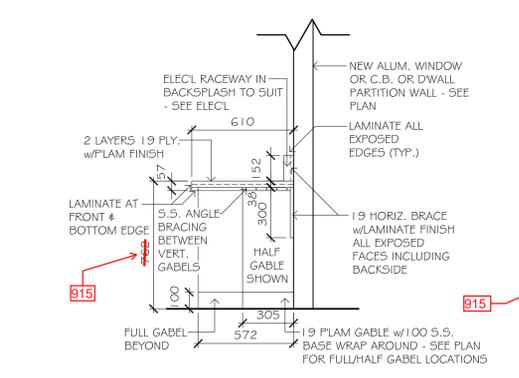


6 NEW LIBRARY RESOURCE RM COUNTER SECTION
 SCALE: 1:20

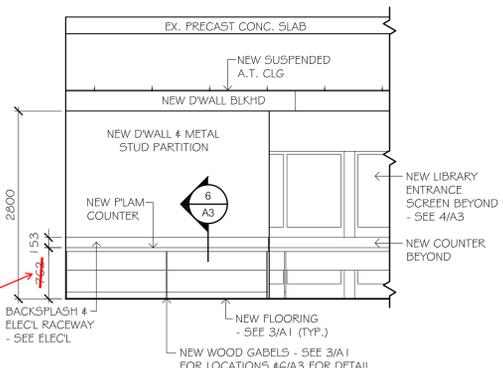


7 NEW COUNTER ELEVATION
 SCALE: 1:50

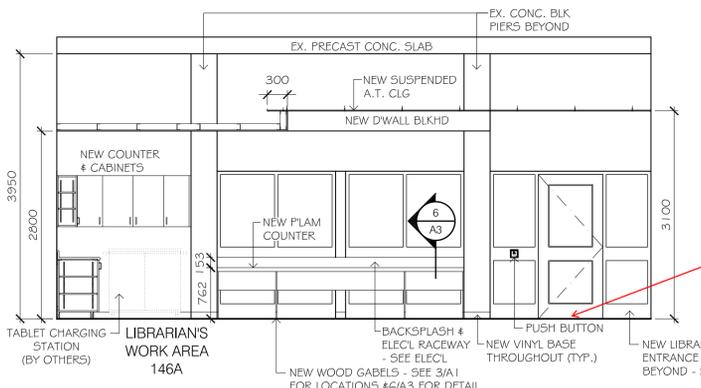


8 NEW LIBRARY WEST WALL ELEVATION
 SCALE: 1:50

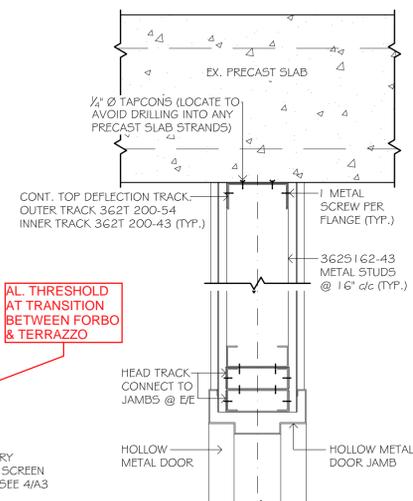

9 NEW HEADER H1
 SCALE: 1:5

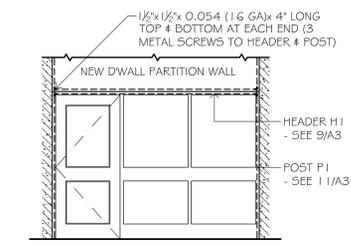

10 NEW HEADER/POST DETAIL @ OPENING
 SCALE: 1:50

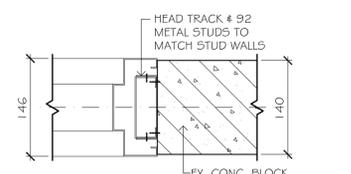

11 NEW POST P1 DETAIL
 SCALE: 1:5

SNYDER CONSTRUCTION
 AS BUILT DRAWING
 2019-01-22

FOR TENDER & PERMIT	APRIL 27/2018
ISSUED:	DATE:

THIS DRAWING IS COMPLIMENTARY & MUST BE READ IN CONJUNCTION WITH ALL THE OTHER DRAWINGS AND/OR SPECIFICATIONS. REPORT ANY INCONSISTENCIES TO THE ARCHITECT.

PROJECT:
RENOVATIONS TO ST. PAUL'S ELEMENTARY SCHOOL

2 GRANT AVENUE, LAKEFIELD, ON

DRAWING TITLE:
SECTIONS

SCALE: AS NOTED DRAWING NUMBER:

DRAWN BY: SV

CHECKED BY: GW

A3 OF 4
 17057

