KAWARTHA LAKES POLICE SERVICES PROPERTY ROOM Phase 1



DRAWING LIST:

COVER PAGE

DEMOLITION AND PROPOSED PLAN REFLECTED CEILING PLAN AND LEGEND

ENLARGED FLOOR PLAN: DEMOLITION PLUMBING

ENLARGED FLOOR PLAN: NEW PLUMBING ENLARGED FLOOR PLAN: PIPING DEMOLITION ENLARGED FLOOR PLAN: HVAC DEMOLITION

ENLARGED FLOOR PLAN: PIPING NEW ENLARGED FLOOR PLAN: HVAC NEW

MECHANICAL SCHEDULES


DRAWING LIST, LEGEND, SCHEDULES AND NOTES

PARTIAL FLOOR PLAN - DEMOLITION ELECTRICAL PARTIAL FLOOR PLAN - LIGHTING

PARTIAL FLOOR PLAN - POWER AND SYSTEMS SINGLE LINE DIAGRAM AND PANEL SCHEDULES

02 DRAWING LIST

PHASE 1

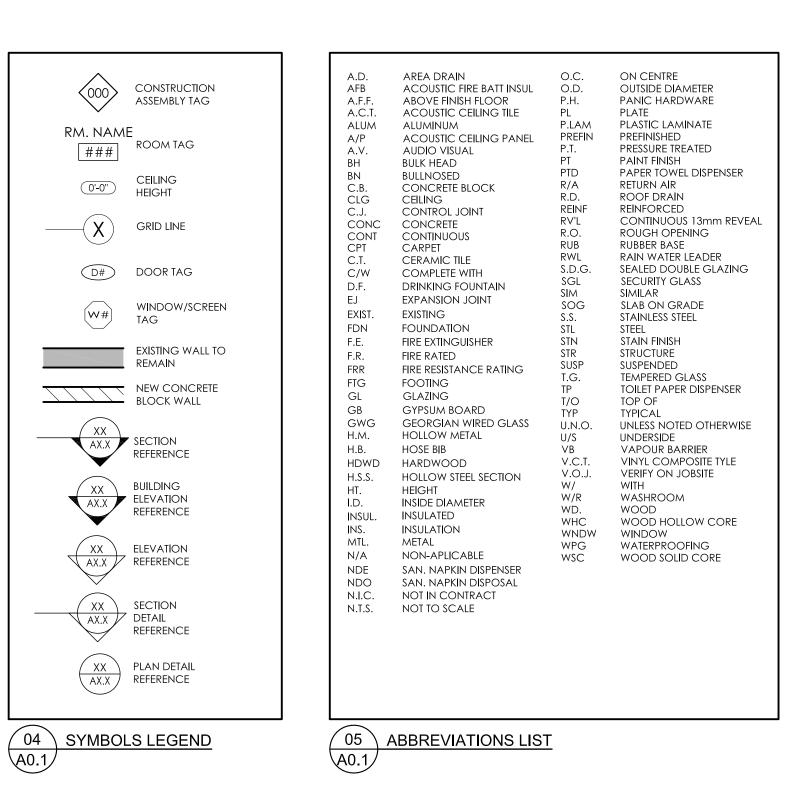

CLIENT:

A0.1 N.T.S.

CITY OF KAWARTHA LAKES

ig/ 01 ackslash KAWARTHA LAKES POLICE SERVICES BUILDING

6 VICTORIA AVE, N LINDSAY, ONTARIO, CANADA K9V 4E5 T: 705-324-9411 EXT. 2328

03 SECOND FLOOR PHASING PLAN

CONTACT: JIM MARSHALL Building & Property imarshall@kawarthalakes.ca **ARCHITECT:**

+VG ARCHITECTS

72 STAFFORD STREET, TORONTO, ONTARIO, CANADA M6J 2R8

T: 416.588.6370 F: 416.588.6327 W: www.plusvg.com CONTACT: CHRIS HALL chall@plusvg.com

MECHANICAL:

VANDERWESTEN&RUTHERFORD

7242 COLONEL TALBOT ROAD LONDON, ONTARIO, CANADA N6L 1H8 T: 519.652.5058 W: www.vreng.ca


CONTACT: **VASILE TUDOR** masilet@vreng.ca **ELECTRICAL**:


VANDERWESTEN&RUTHERFORD

7242 COLONEL TALBOT ROAD LONDON, ONTARIO, CANADA N6L 1H8 T: 519.652.5058 W: www.vreng.ca

CONTACT: **VASILE TUDOR** masilet@vreng.ca **KEY PLAN:** CITY OF KAWARTHA LAKES PROJECT: POLICE SERVICES PROPERTY ROOM - PHASE 1 ROOM RENOVATONS 6 VICTORIA STREET NORTH ORIGINAL PAGE SIZE ARCH D - 24" x 36" KEY TO DETAIL LOCATION: A - DETAIL NO.
B - DETAIL NO. ORIGIN ARCHITECTS
THE VENTIN GROUP LTD

03 21/09/01 ISSUED FOR TENDER & PERMIT

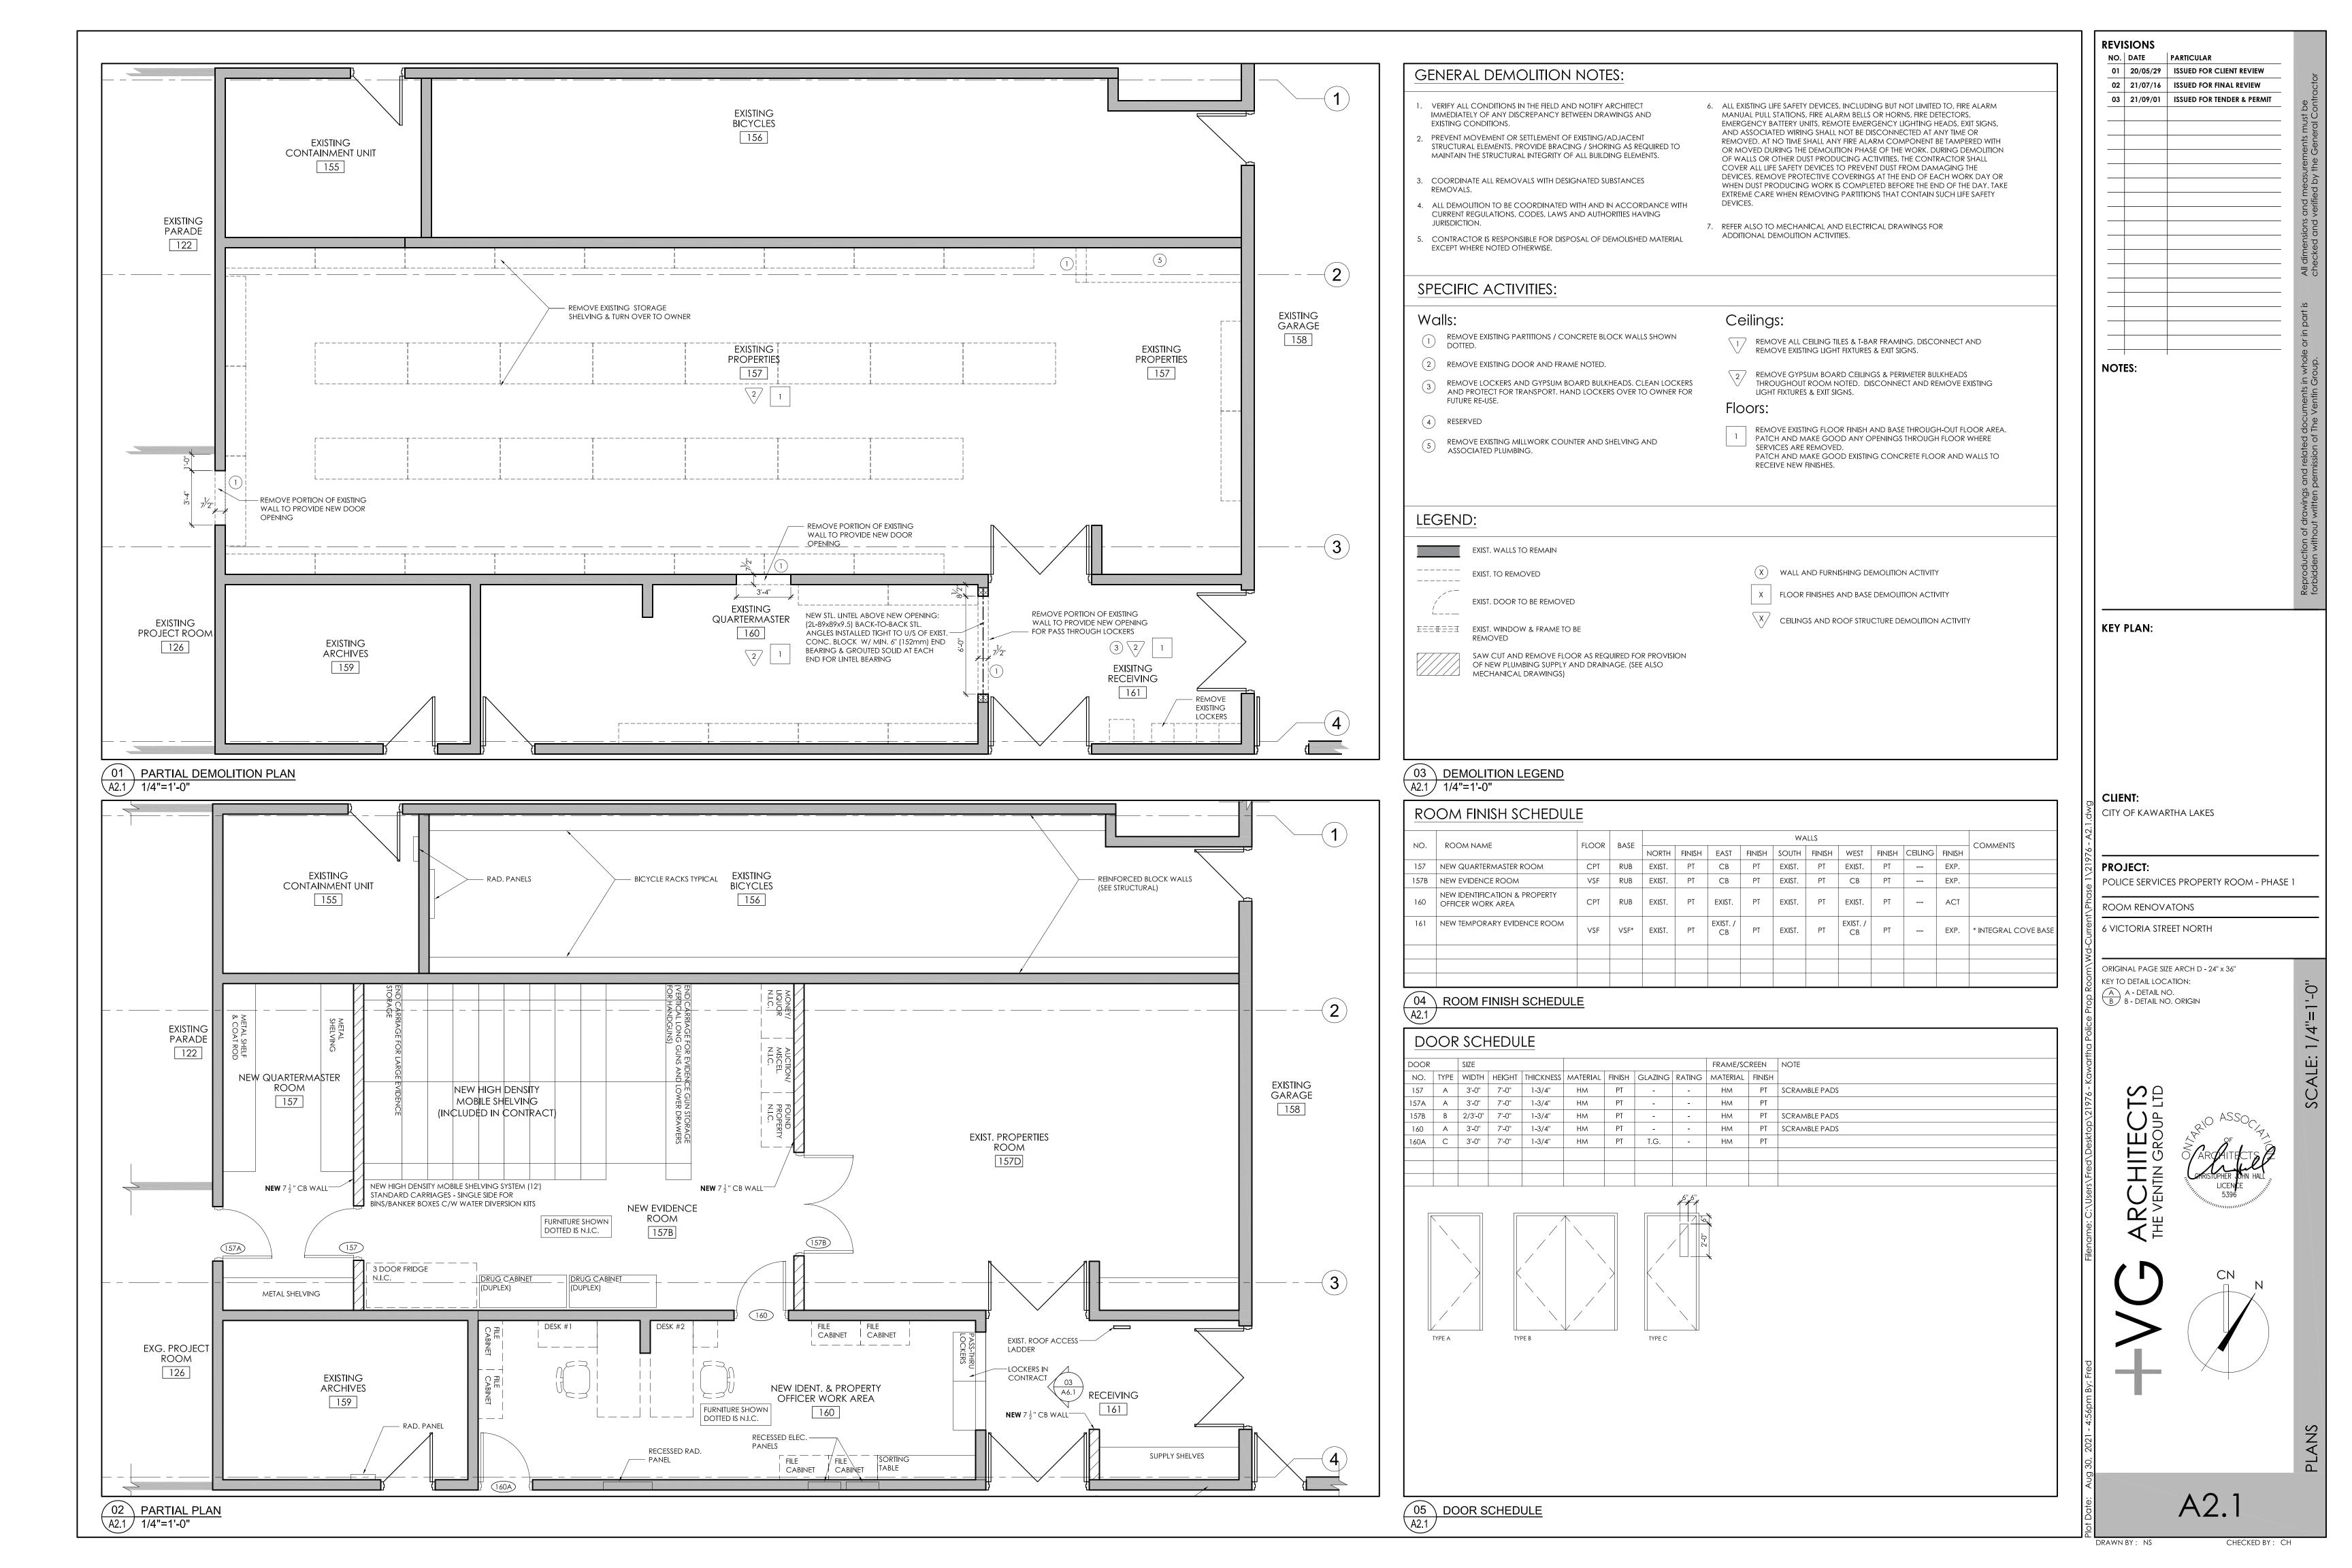

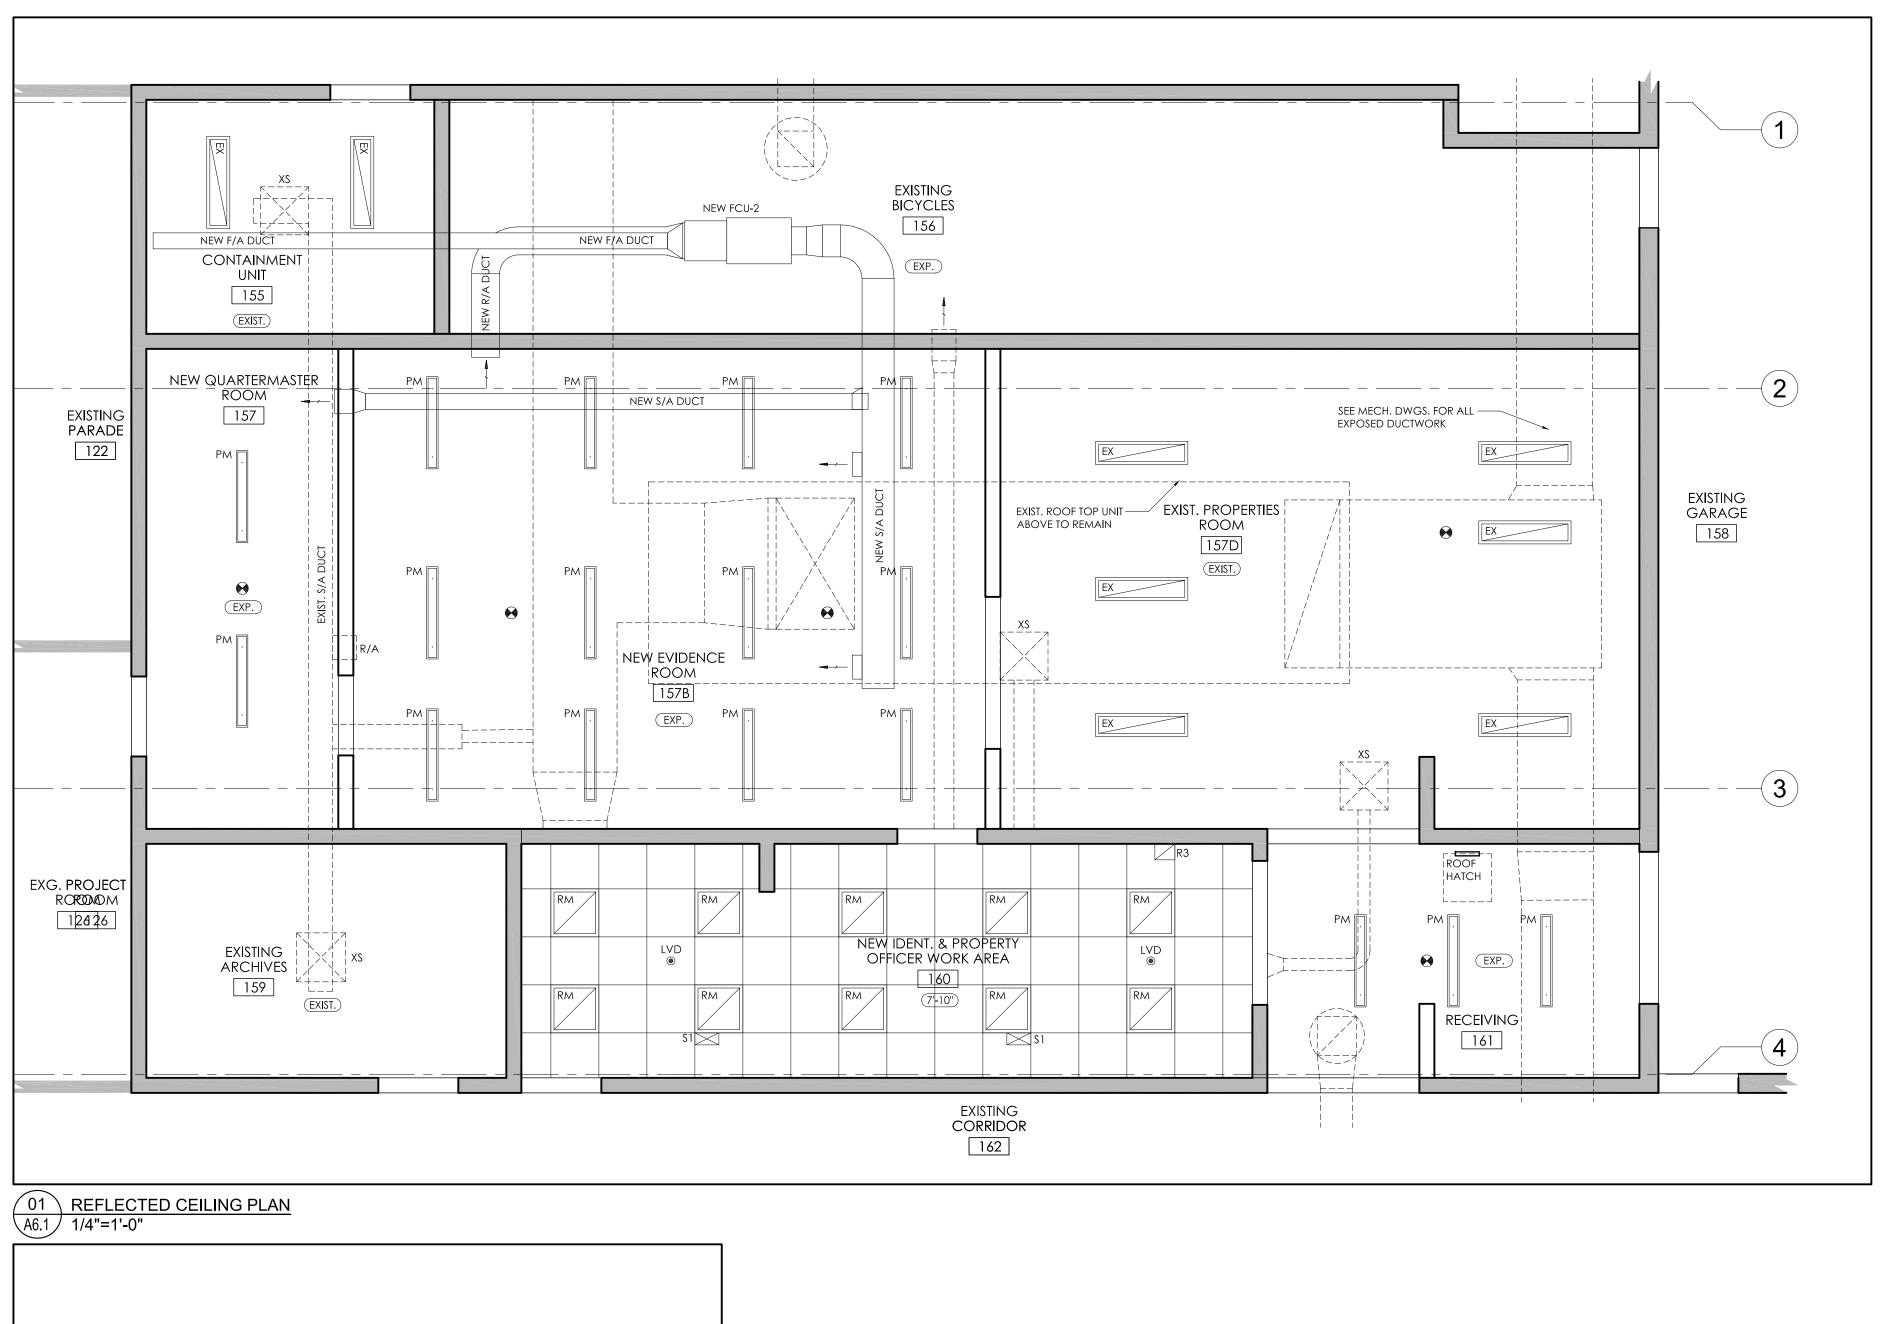

CEILING SYMBOLS & ABBREV.'S LEGEND NEW CEILING TILES 610x610 TYPE A.T.2 NEW GYPSUM BOARD CEILING TO BE PTD. SEAL AROUND PERIMETER. NEW CEILING HEIGHT ABOVE FINISHED EXISTING CEILING & HEIGHT ABOVE NEW CEILING MOUNTED LIGHT FIXTURE PM PM (PENDANT FLUORESCENT) (COORD. W/ ELEC. DWG.'S) NEW CEILING MOUNTED LIGHT FIXTURE (RECESSED FLUORESCENT) (COORD. W/ ELEC. DWG.'S) EXISTING LIGHT FIXTURE (COORD. W/ ELEC. DWG.'S) NEW SURFACE MOUNTED LIGHT FIXTURE (FLUORESCENT) (COORD. W/ ELEC. DWG.'S) NEW SUPPLY AIR GRILLE (COORD. W/ MECH. DWG.'S) EXISTING SUPPLY AIR GRILLE (COORD. W/ MECH. DWG.'S) RETURN AIR GRILLE / EXHAUST VENT (COORD. W/ MECH. DWG.'S) LOW VOLTAGE DIMMER CONTROL (COORD. W/ ELEC. DWGS.) FIXED TEMPERATURE HEAT (COORD. W/ ELEC. DWGS.) RECESSED LIGHT FIXTURE (COORD. W/ ELEC. DWGS.) GENERAL NOTES COORD. W/ MECH. & ELEC. DWG.'S FOR RESPECTIVE CEILING MTD. OR RECESSED ITEMS FINAL LOCATION OF ALL MECH. & ELEC. FIXTURES TO BE CONFIRMED PRIOR TO INSTALL. COORD. ALL MECH. & ELEC. ITEMS W/ ARCH. DWGS. & REPORT ANY DISCREPANCIES PRIOR TO ANY WORK FINAL LOCATION OF SPRINKLERED ITEMS NOT SHOWN IN ARCH. DWG.'S TO BE CONFIRMED @ SHOP DWG. REVIEW UNLESS DIMENSIONED OTHERWISE, CEILING TILES TO BE STARTED AS SHOWN FROM THE CENTER POINT OF ROOMS INT. CEILING BULKHEAD SYSTEMS TO BE CONSTRUCTED W/ METAL FRAMING TYP., NOT WD.

O2 SYMBOLS LEGEND & GENERAL NOTES
A6.1 1/4"=1'-0"

REVISIONS NO. DATE PARTICULAR 01 20/05/29 ISSUED FOR CLIENT REVIEW 02 21/07/16 ISSUED FOR FINAL REVIEW 03 21/09/01 ISSUED FOR TENDER & PERMIT NOTES: KEY PLAN: CITY OF KAWARTHA LAKES PROJECT: POLICE SERVICES PROPERTY ROOM - PHASE 1 ROOM RENOVATONS 6 VICTORIA STREET NORTH ORIGINAL PAGE SIZE ARCH D - 24" x 36" KEY TO DETAIL LOCATION: A - DETAIL NO. B - DETAIL NO. ORIGIN REFLECTED CEILING PLAN, LEGEND & NOT

MEN ST. LINTE. ABOVE NEW CPENING.

CILEMPREYS SI BACK-TO-BACK ST. ANCLES
INSTALLED TIGHT TO US OF ERIST CONC.
BLOCK WINN AS (1) SEPRING BED BLARRING
A GROUPD SOULD A FEACH END FOR
LINTEL BASHING

REINFORCED FILLER
PRANL INSTED TO
MAICH I COCKES

3.07

3.07

A6.1 1/2"=1'-0"

A6.1

Y: NS CHECKED BY: CH