





-  EXIT
-  PULL STATIONS
-  FIRE EXTINGUISHER - DRY
CHEMICAL, H2O, CO2
-  SMOKE DETECTORS
-  AUTOMATIC HEAT DETECTORS
-  EMERGENCY LIGHTING UNIT
DOUBLE
-  EMERGENCY LIGHTING UNIT
SINGLE
-  SINGLE HORN SPEAKER
-  ATTIC ACCESS
-  ENGINEERED AIR SWITCH
-  MUA DAMPER

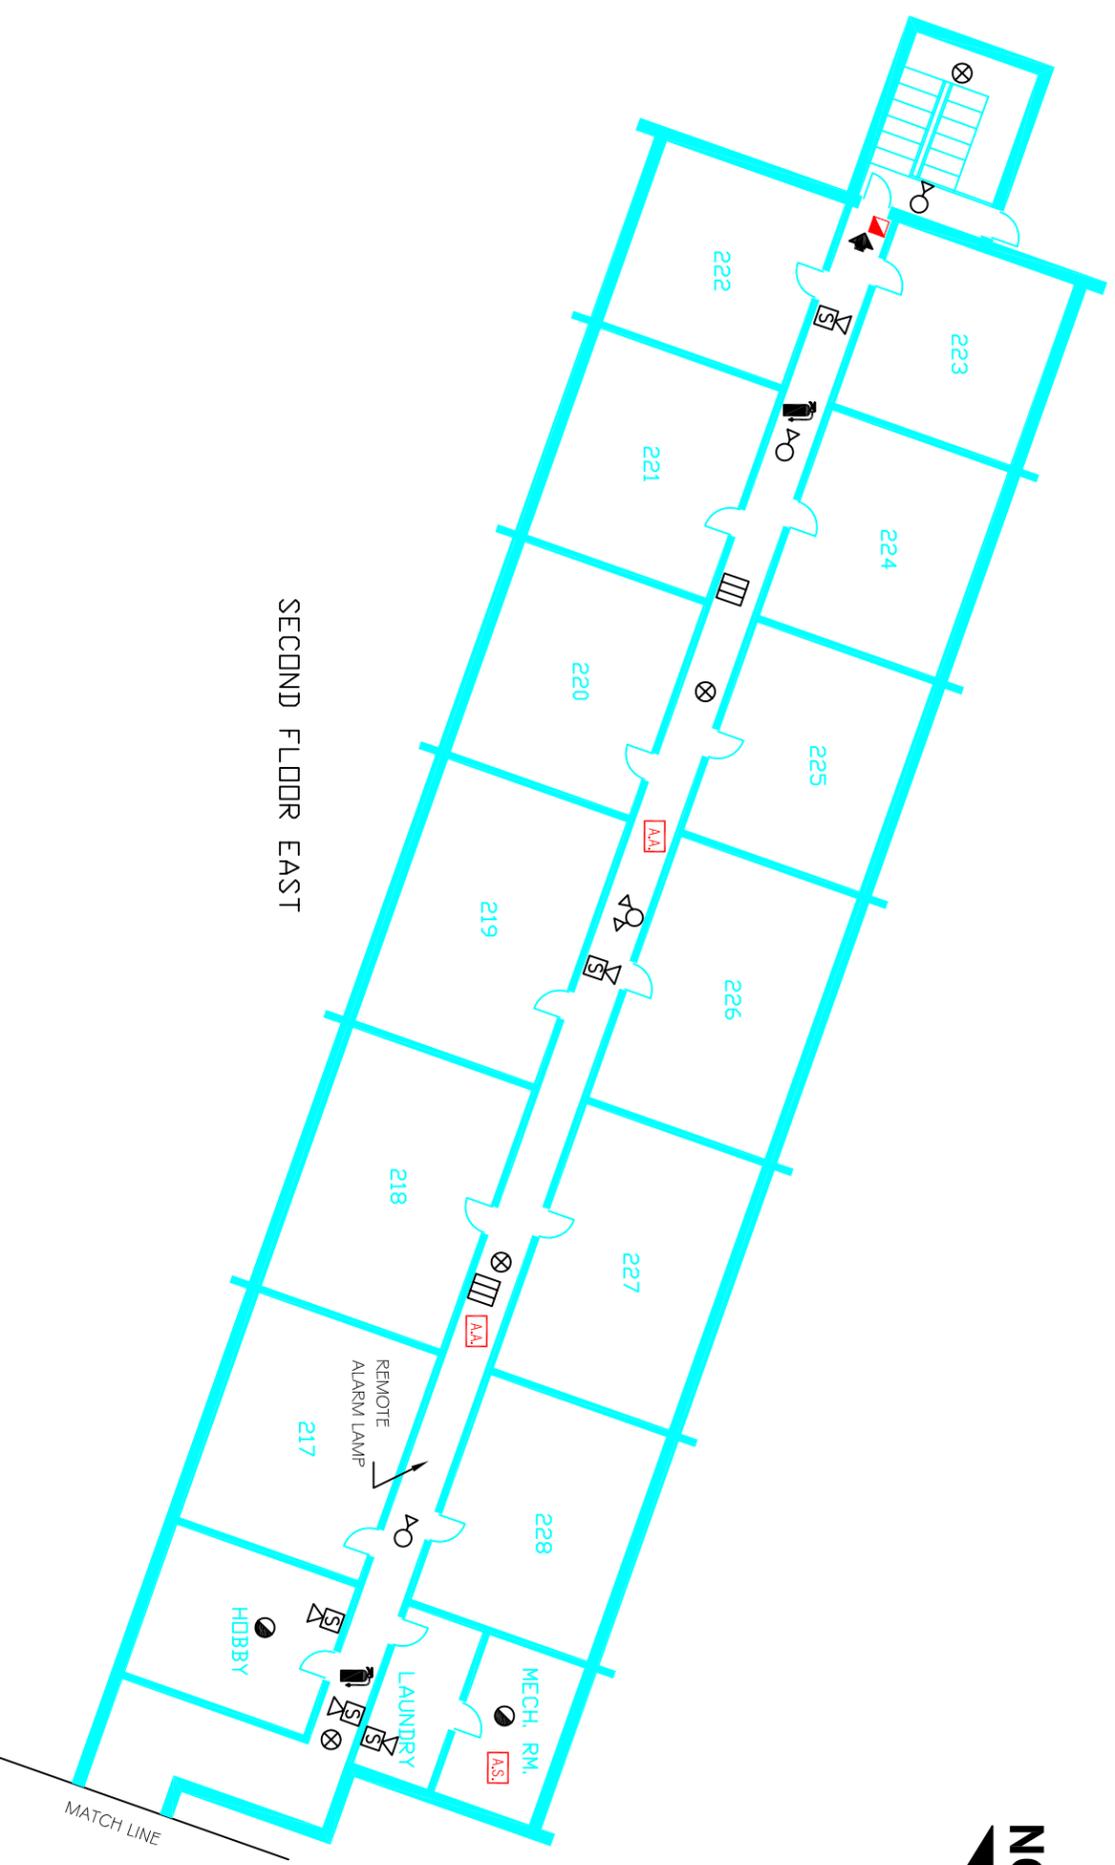

SECOND FLOOR EAST

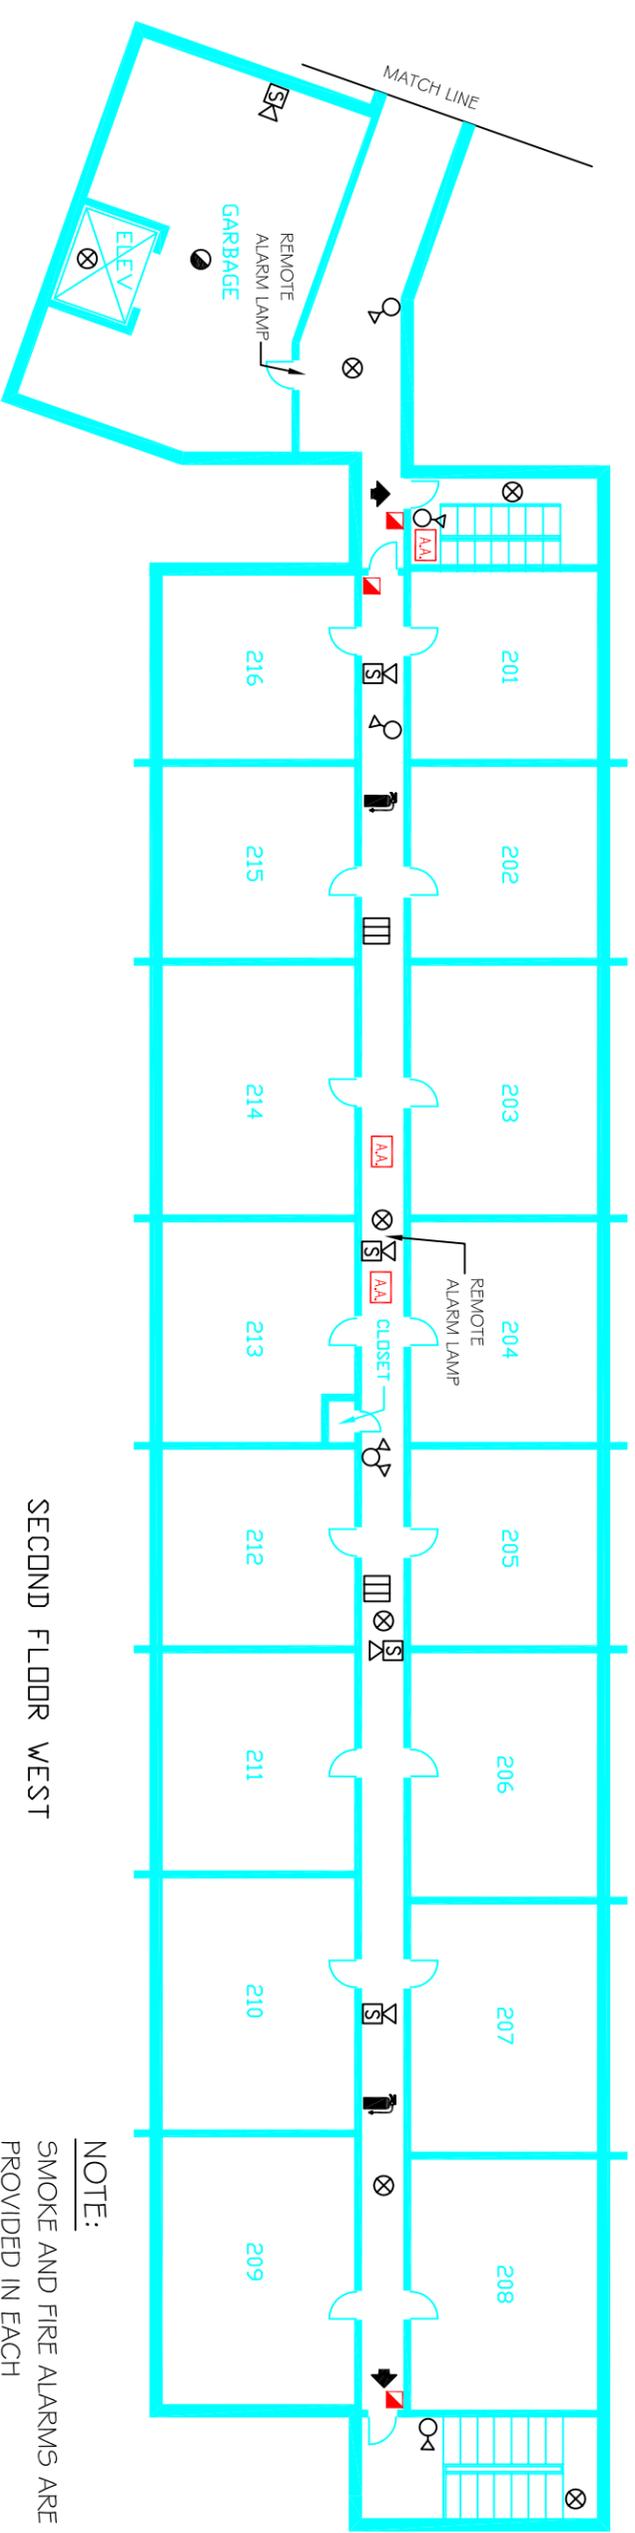

SECOND FLOOR WEST

NOTE:
SMOKE AND FIRE ALARMS ARE
PROVIDED IN EACH
RESIDENTIAL SUITE.

FIRE SAFETY PLAN

20 PERRY ST.
UXBRIDGE, ONT.

DATE: JANUARY, 2005

SCALE: N.T.S.

SECOND FLOOR PLAN