




- ENGINEERED AIR SWITCH
- EXIT
- PULL STATIONS
- FIRE EXTINGUISHER - DRY CHEMICAL, H2O, CO2
- SMOKE DETECTORS
- AUTOMATIC HEAT DETECTORS
- EMERGENCY LIGHTING UNIT SINGLE
- SINGLE HORN SPEAKER
- EMERGENCY LIGHTING UNIT WITH BATTERY PACK
- SPRINKLER SYSTEM SHUTOFF VALVE
- MAIN ELECTRICAL SHUTOFF
- ATTIC ACCESS
- GAS SHUTOFF
- MUA DAMPER

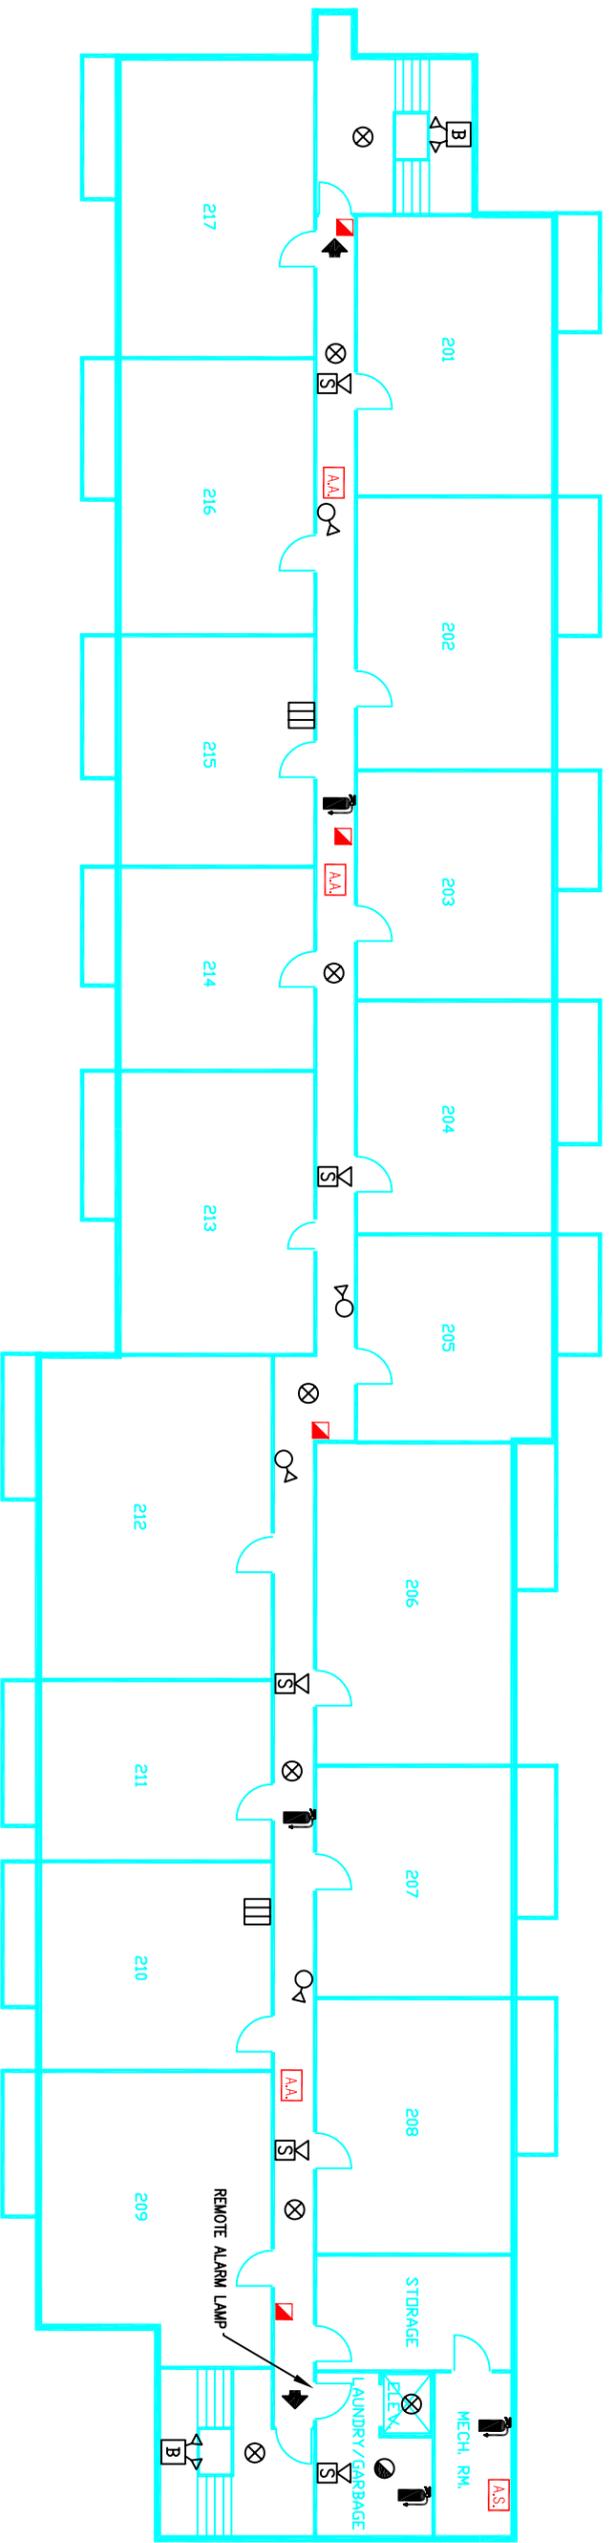

## FIRE SAFETY PLAN

342 MAIN ST.  
BEAVERTON, ONT.

DATE: JANUARY, 2005

SCALE: N.T.S.

## SECOND FLOOR PLAN

**NOTE:**  
SMOKE AND FIRE ALARMS ARE PROVIDED IN EACH RESIDENTIAL SUITE.